


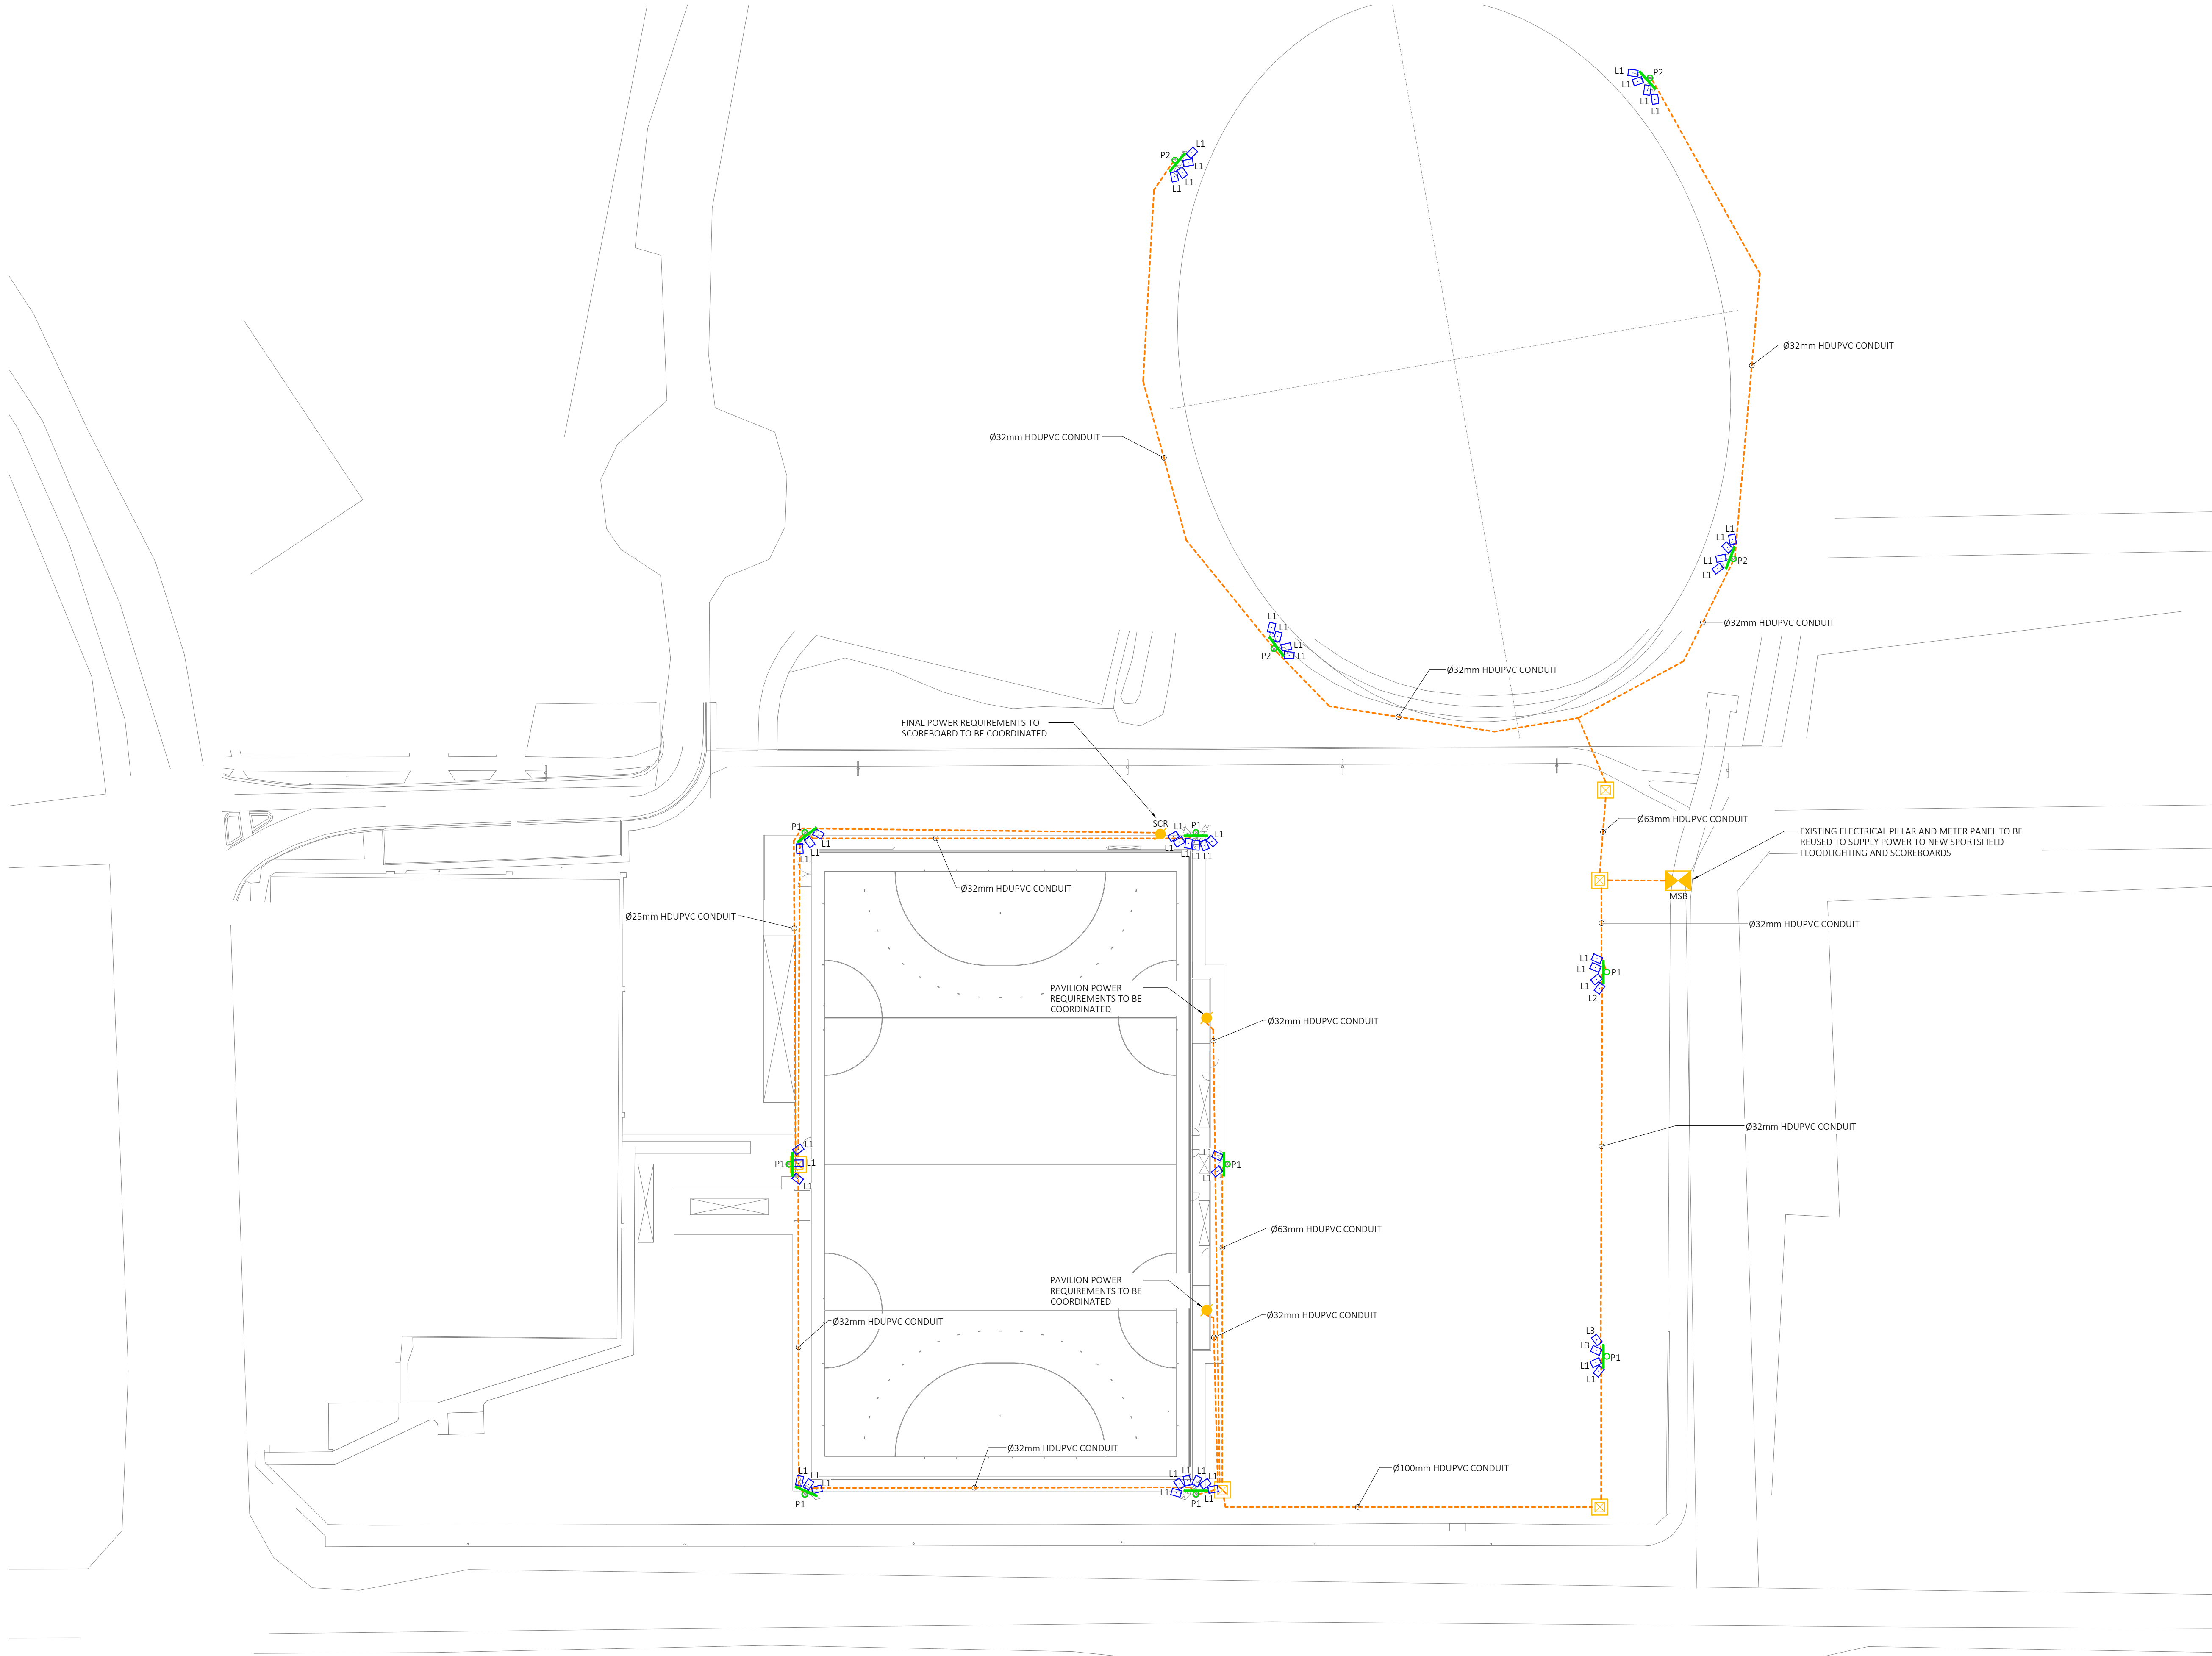

IINGEN PTY LTD IS THE OWNER OF THE COPYRIGHT SUBSISTING IN THESE DRAWINGS AND SPECIFICATIONS WHICH MUST NOT BE REPRODUCED OR COPIED WITHOUT PRIOR WRITTEN CONSENT.

DO NOT SCALE DRAWINGS. USE FIGURED DIMENSIONS ONLY. VERIFY ALL DIMENSIONS ON SITE. IF IN DOUBT, PLEASE ASK.

- GENERAL NOTES**
- A. THIS DRAWING SHALL BE READ IN CONJUNCTION WITH THE ARCHITECTURAL DRAWINGS AND ALL OTHER RELEVANT SERVICES DRAWINGS.
 - B. FINAL POSITIONS OF ALL EQUIPMENT TO BE DETERMINED ON SITE PRIOR TO INSTALLATION.
 - C. POSITIONS OF ANY EXISTING SERVICES SHOWN ARE APPROXIMATE. THE EXIST LOCATIONS AND EXTENT OF EXISTING EQUIPMENT SHALL BE VERIFIED ON SITE BY THE CONTRACTOR PRIOR TO COMMENCING WORK. SUBMIT A DIAL BEFORE YOU DIG REQUEST PRIOR TO COMMENCING WORK AND EXERCISE CAUTION WHEN EXCAVATING.
 - D. WHERE POSSIBLE, ALL POWER AND COMMUNICATIONS CONDUITS SHALL BE INSTALLED IN COMMON TRENCHES WITH THE OTHER SERVICES TRADES. CONTRACTOR IS TO ENSURE THAT THE MINIMUM REQUIRED CLEARANCE IS MAINTAINED BETWEEN SERVICES THAT RUN IN COMMON TRENCHES.
 - E. ALL CONDUITS SHALL BE SEALED TO PREVENT WATER INGRESS AFTER INSTALLATION OF CABLEING.
 - F. ALL CONDUITS SHALL BE FITTED WITH DRAW ROPE REGARDLESS OF WHETHER THE CONDUITS CONTAIN CABLES OR NOT.
 - G. WATTMASTER OR EQUIVALENT ORANGE CABLE WARNING TAPE SHALL BE INSTALLED 300MM ABOVE ALL CONDUITS AND CABLES.
 - H. ALL PITS INSTALLED WITHIN TRAFFICABLE AREAS SHALL BE PROVIDED WITH CLASS D LIDS IN ACCORDANCE WITH AS3996.
 - I. CONDUITS ENTERING PITS ARE TO BE FITTED WITH BUSHINGS. BUSHING ARE TO BE SEALED AND FLUSH AGAINST THE PIT EDGE.
 - J. CABLE PITS SHALL BE USED AT CHANGES OF DIRECTION AND AT INTERVALS NOT EXCEEDING 50M. ALLOW IN THE TENDER PRICE TO SUPPLY AND INSTALL ADDITIONAL PITS IF REQUIRED.
 - K. MAKE GOOD ALL SURFACE FINISHES TO MATCH ORIGINAL FINISH AND GROUND LEVEL.

T1	20.02.26	Issued for Tender
B	20.01.26	Issued for Approval
A	14.11.25	Issued for Review
Issue	Date	Description

AMENDMENTS

BUILDING SERVICES CONSULTANTS
IINGEN PTY LTD
U111 50 Holt Street, Surry Hills NSW 2010
Email: info@iingen.com.au



CLIENT

SPORTENG

PROJECT

McDONALD RESERVE
66 BELL ST., COBURG VIC 3058

DRAWING TITLE

ELECTRICAL SERVICES
LIGHTING LAYOUT

STATUS

TENDER

SCALE @ A1 1:500 PROJECT No. IIN25146

DESIGNED	DESIGN REVIEW	APPROVED PD
IDV	MM	SD

DRAWING No.	AMDT
E-010	T1